


REVISION AT

DESCRIPTION	-
CLIENT	New World Millennium Hong Kong Hotel
JOB	Public Area Renovation
DRAWING TITLE	Proposed Layout Floor Plan of B2/F Staff Canteen
DESIGNED BY	THOMAS
DRAFTED BY	THOMAS
DRAFTING DATE	Jan-2018
ISSUE AUTHORIZED BY	
SCALE	1 : 75
UNIT	MM
DRAWING NO.	GF - PL - 01



Legend	
Symbol	Descriptions
	EXISTING CORE WALL
	100mm THK NEW CONSTRUCT BRICK WALL
	75mm THK WOODEN PARTITION
	75mm THK GYPSUM BOARD PARTITION
	75mm Thk FULL HEIGHT GLASS PARTITION
	30mm Thk FURNITURE PARTITION

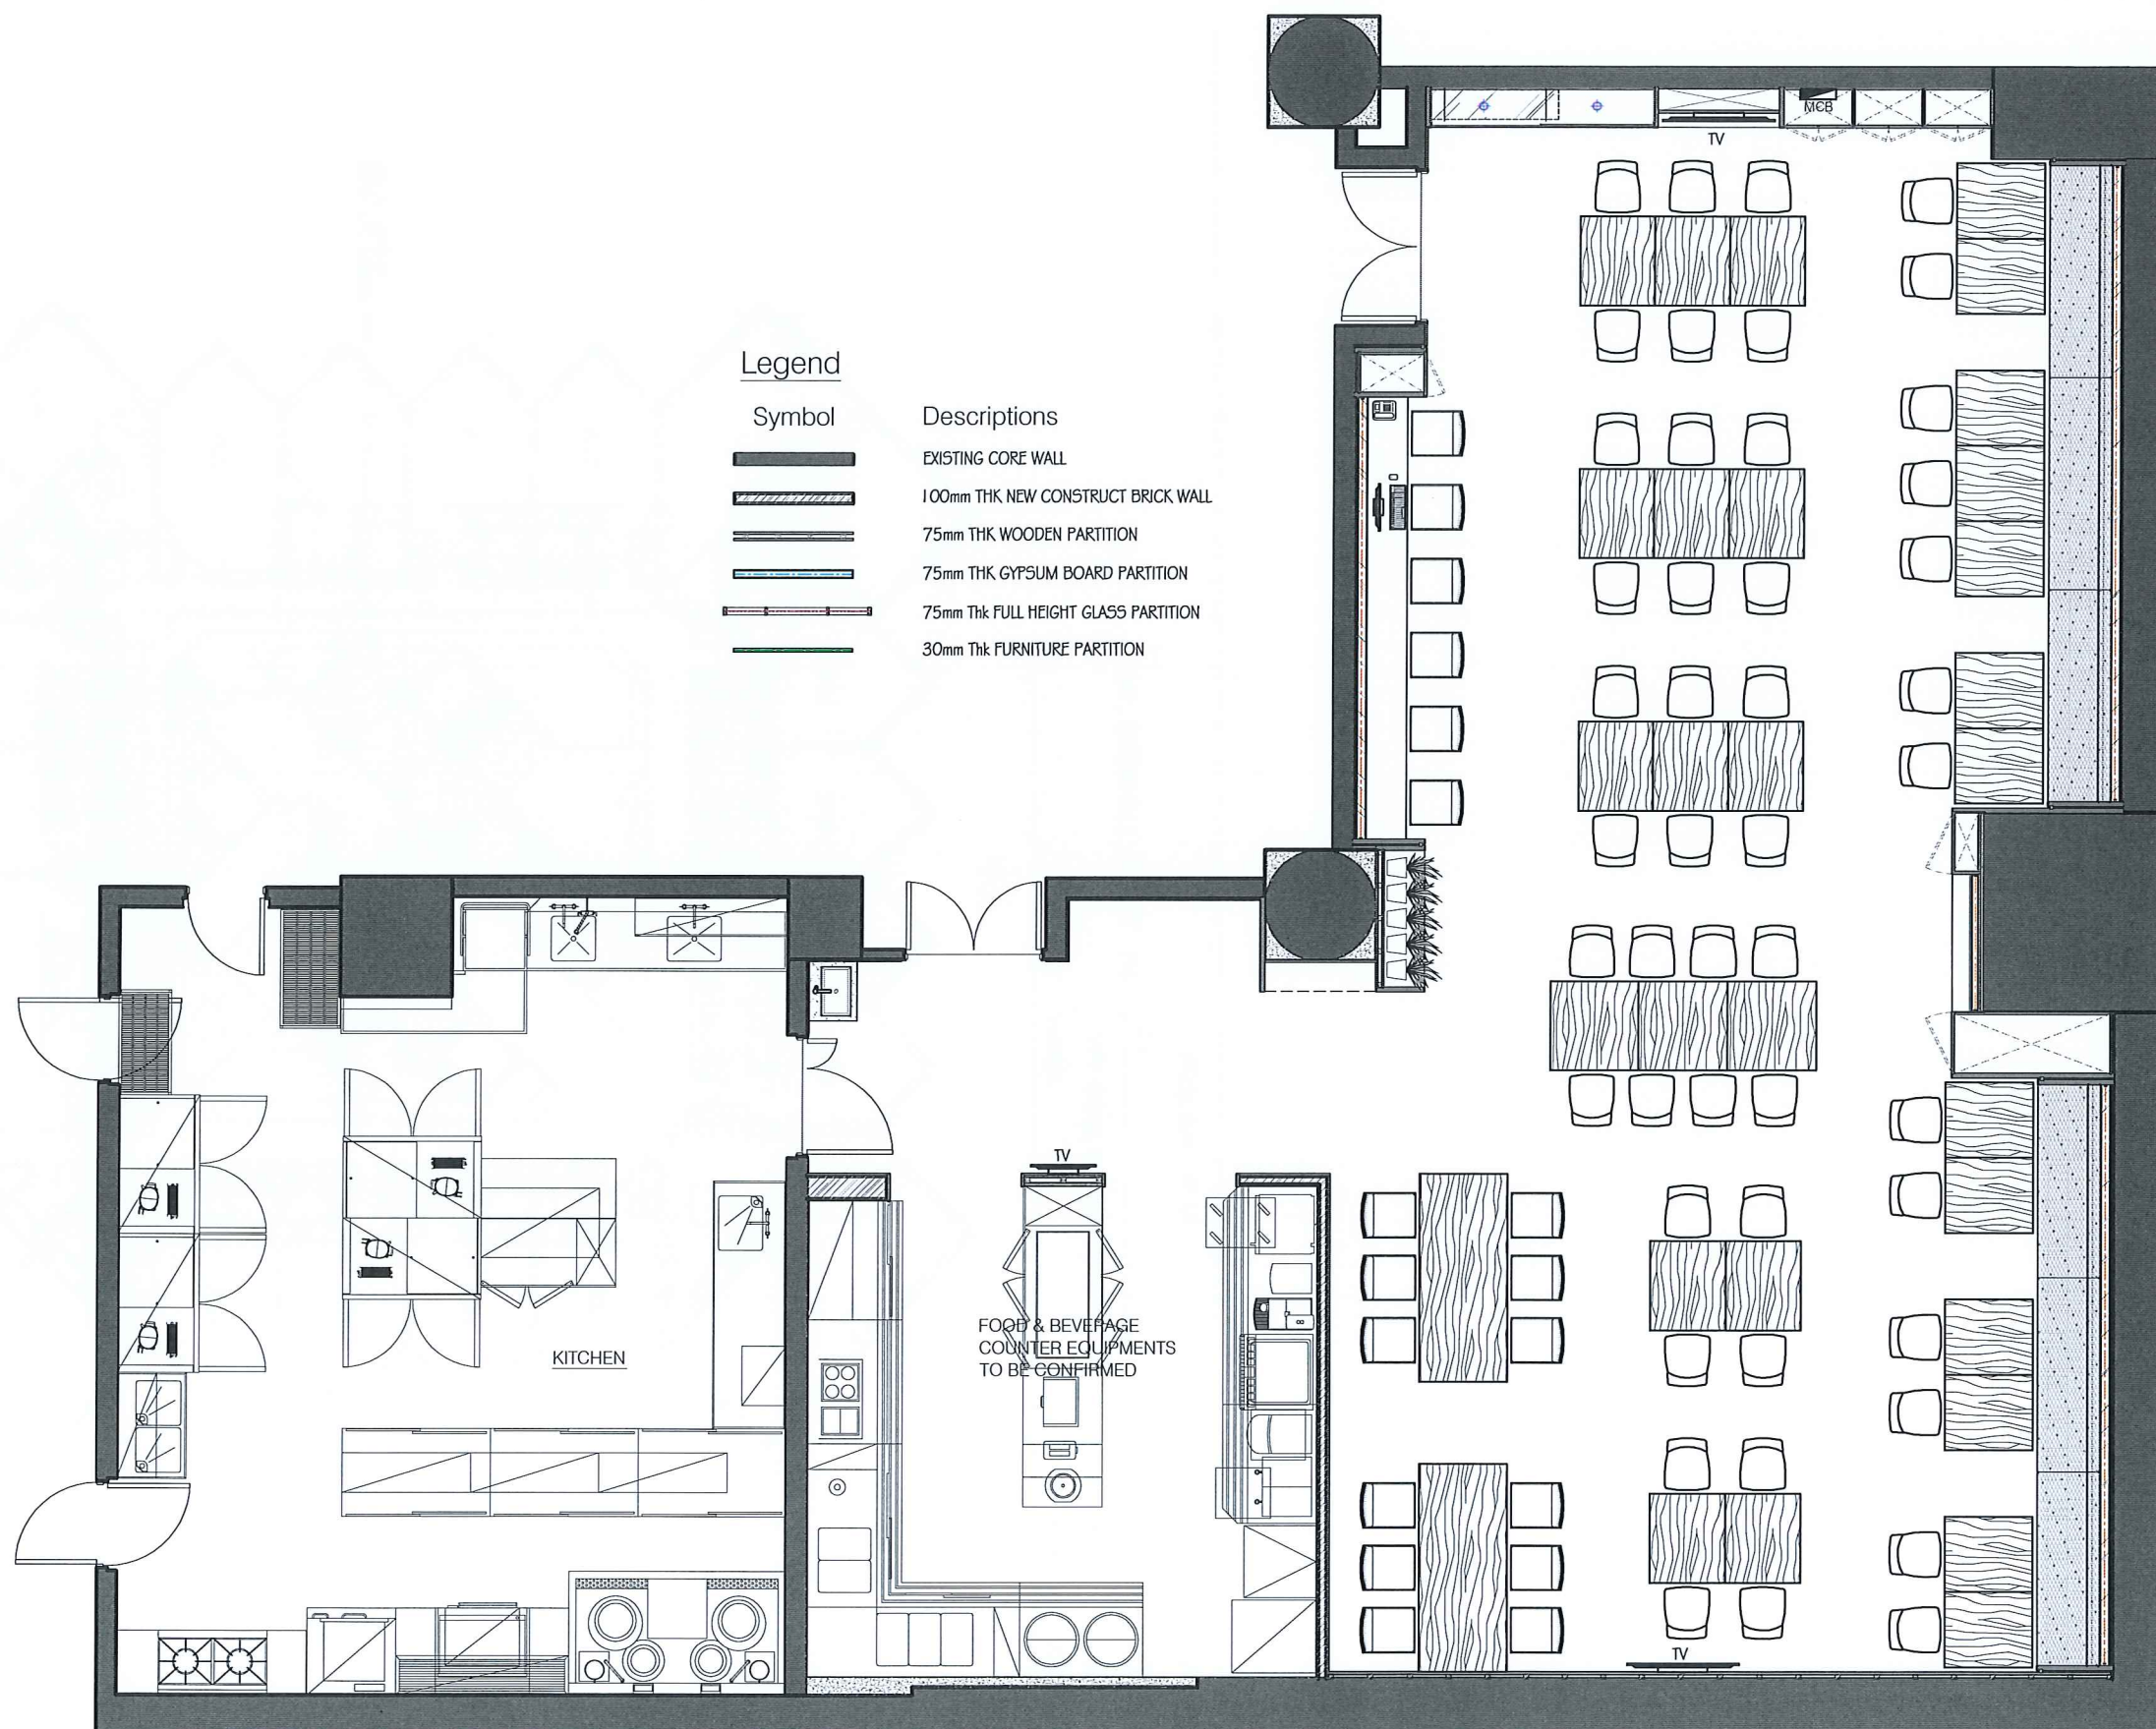

01
PL

Proposed Layout Floor Plan of B2/F Staff Cateen
Scale 1: 75

B2/F Staff Canteen Area 161 SM (Not Include Kitchen)

SYMBOL	DESCRIPTIONS	QTY.
	Dia. 96mm LOW VOLTAGE LED SINGLE LIGHT BULB RECESSED DOWN LIGHT	39
	Dia. 133mm LOW VOLTAGE LED SINGLE LIGHT BULB DOWN LIGHT	22
	LED STRIP LIGHT	
	WIFI ROUTER	
	PUBLIC ADDRESS SYSTEM	
	CCTV SHOT	
	13AMP POWER SPUR ABOVE THE FALSE CEILING	
SW 11~12	LIGHTING SWITCH	

SYMBOL	DESCRIPTIONS	QTY
	AC RETURN LOURVE	3
	AC SUPPLY DIFFUSER	7
	THERMOSTAT PLATE	3

SYMBOL	DESCRIPTIONS	QTY.
	68°C SPRINKLER HEAD	10
	RECESSED EMERGENCY LIGHT	6
	EXIT SIGNS	1
	DIRECTIONAL EXIT SIGNS	1



與美設計工程有限公司
HENMAX LTD.