



Lobby Lounge

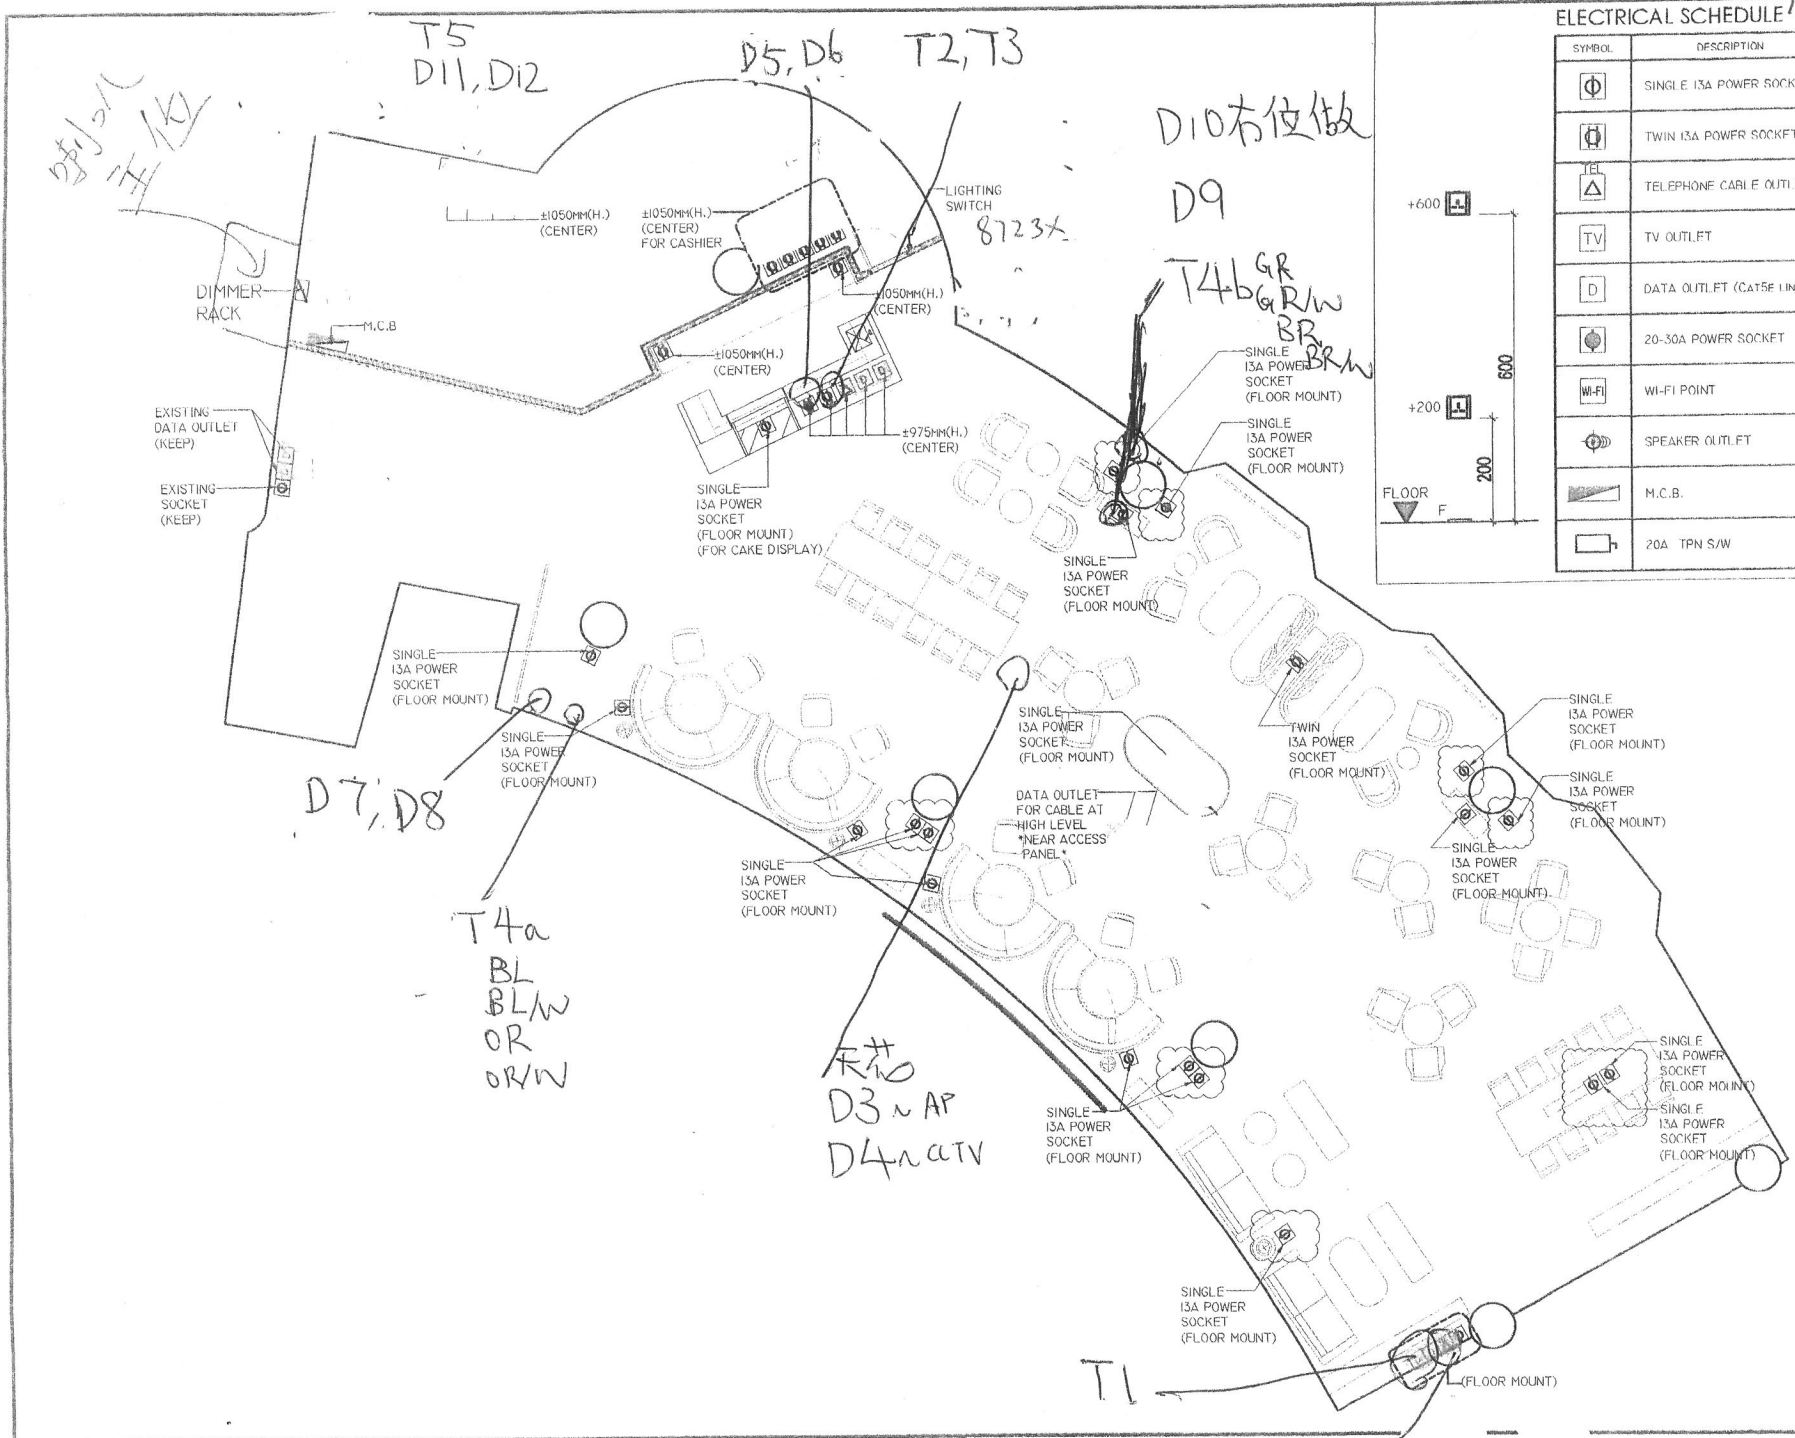

ELECTRICAL SCHEDULE

SYMBOL	DESCRIPTION	QTY.
	SINGLE 13A POWER SOCKET	---
	TWIN 13A POWER SOCKET	---
	TELEPHONE CABLE OUTLET	---
	TV OUTLET	---
	DATA OUTLET (CAT5E LINE)	---
	20-30A POWER SOCKET	---
	WI-FI POINT	---
	SPEAKER OUTLET	---
	M.C.B.	---
	20A TPN S/W	---

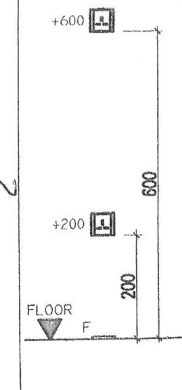

REVISION AT

REVISION	DATE	DESCRIPTION
R 4/03		GENERAL REVISION
A 10/03		GENERAL REVISION

REMARK

- CHECK ALL MEASUREMENT ON SITE, DO NOT SCALE OF DRAWINGS.
- THE DRAWING TO BE READ IN CONJUNCTION WITH SPECIFICATION AND ANY DISCREPANCIES ARE TO BE IMMEDIATELY REPORTED TO DESIGNER.
- ALL DRAWINGS ARE DESIGN INTENT ONLY, CONTRACTOR IS REQUIRED TO SUBMIT SHOP DRAWINGS TO DESIGNER FOR APPROVAL.

nude

nude design limited

Copyright, design and all other rights reserved the property of NUDE. No part of this drawing may be used, reproduced or copied without the written permission of NUDE.

DESCRIPTION

CLIENT

NEW WORLD

JOB

New World Millennium Hong Kong

DRAWING TITLE

ELECTRICAL PLAN

DESIGNED BY

DRAFTED BY

DRAFTING DATE

MAR 2016

ISSUE AUTHORIZED BY

SCALE

1:100

UNIT

MM

DRAWING NO.

EP/1007

HENMAX LTD.