


	13AMP TWINS POWER SOCKET AT WALL MOUNTED AFFL
	TWINS DATA OUTLET AT WALL MOUNTED AFFL
	SINGLE TELEPHONE OUTLET AT WALL MOUNTED AFFL

Total: 6 Data socket,
1 Telephone socket

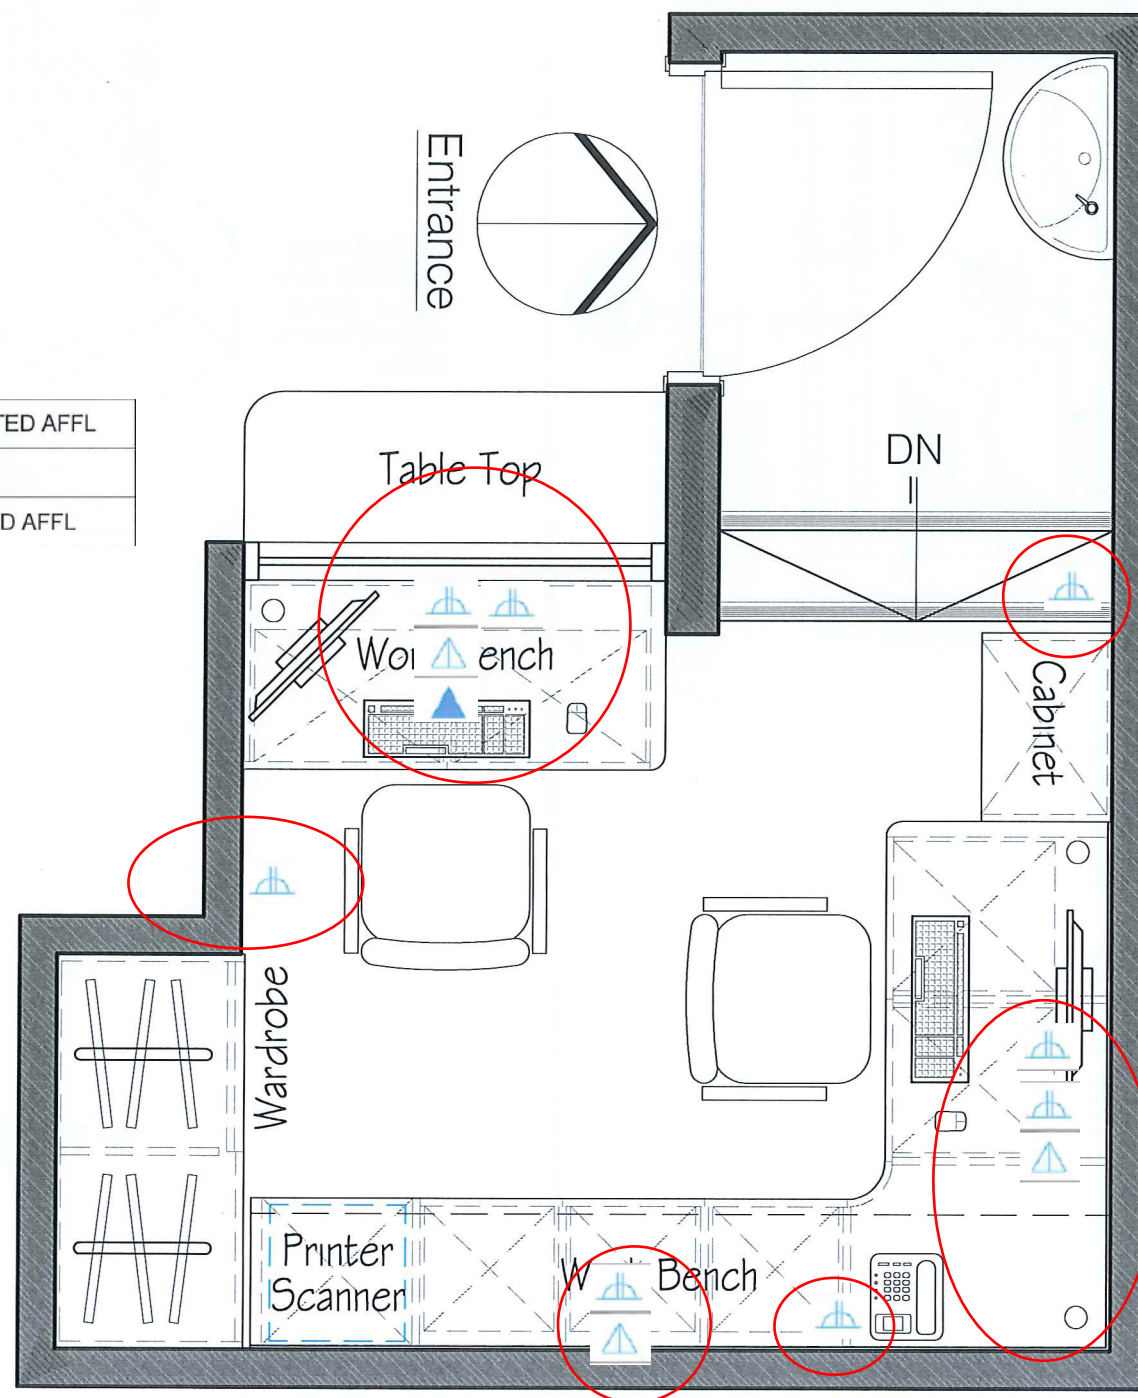

Area 6.7 SM

01
PL

Proposed Layout Floor Plan of G/F Loading Dock Receiving Office

Scale 1: 20

REVISION AT

DESCRIPTION

CLIENT

New World Millennium
Hong Kong Hotel

JOB

Public Area Renovation

DRAWING TITLE

Proposed Layout Floor Plan of G/F
Loading Dock Receiving Office

DESIGNED BY

Thomas

DRAFTED BY

Thomas

DRAFTING DATE

May-2018

ISSUE AUTHORIZED BY

SCALE

1:20

UNIT

MM

DRAWING NO.

GF - PL - 01



興美設計工程有限公司

HENMAX LTD.